


ATTACHMENT 7 PROJECT LOCATION

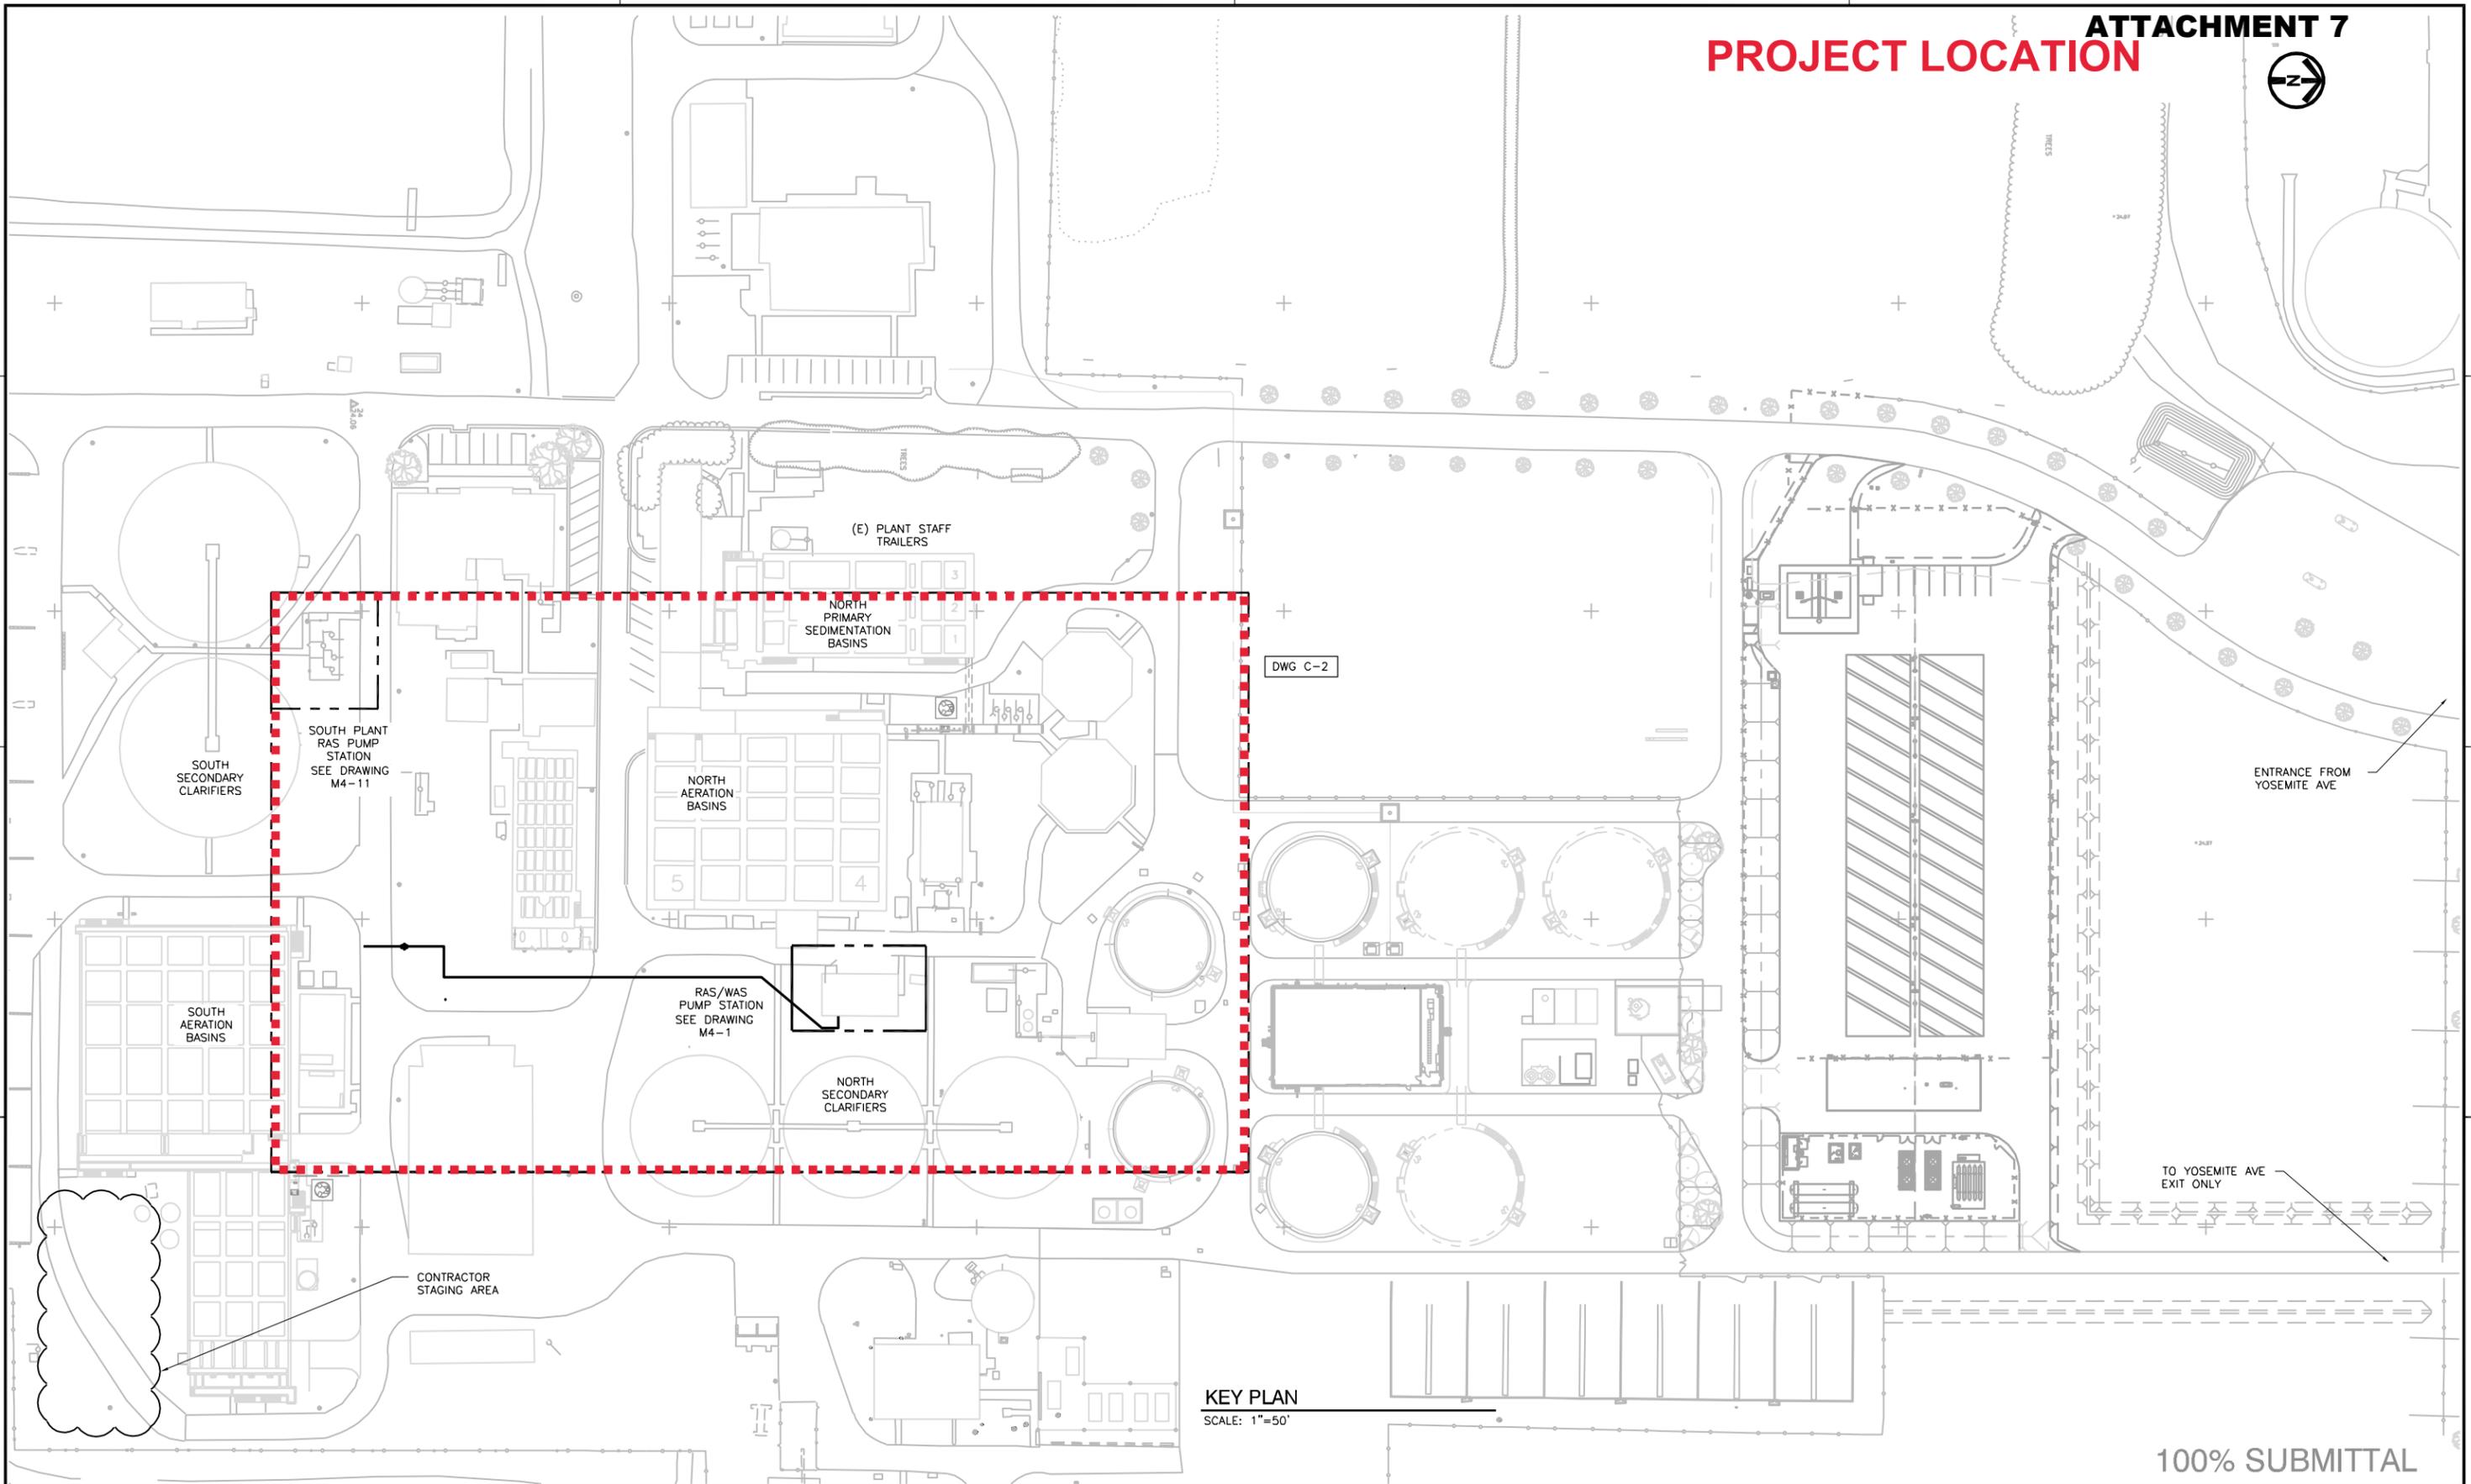

DWG C-2

KEY PLAN
SCALE: 1"=50'

100% SUBMITTAL

R:\Monteca\Capacity - WAS Pumps\Drawings\Working - Temp\HMAN-was-c-1-2 - M4-13 - E-2 6-16-23 03:12pm Ianna : X-MAN-Site Plan; X-MAN-Topo; X-MANT-Foot; X-MANT-H2S - SHIFTEED; X-MANT-Flore - CLASS; x_manteca_eng_plan; X-MANT-CNG Bldgs; X-MANT-Deb2; X-MANT-Deb3;

REV.	DATE	BY	DESCRIPTION

FILENAME:

DESIGNED KAG	DISCIPLINE ENGINEER
DRAWN IG	
CHECKED GPH	
DATE JUNE 2023	

PROJECT ENGINEER

**HERWIT
ENGINEERING**



**CITY OF
MANTECA**

CITY OF MANTECA WASTEWATER QUALITY CONTROL FACILITY
SOUTH RAS & N/S WAS PUMP REPLACEMENT PROJECT

CML
SITE LAYOUT
KEY PLAN

VERIFY SCALES
BAR IS ONE INCH ON
ORIGINAL DRAWING
0 1"

IF NOT ONE INCH ON
THIS SHEET, ADJUST
SCALES ACCORDINGLY

JOB NO.
2022-161 T01
DRAWING NO.
C-1
SHEET NO.
8 OF 59